



GROUND LEVEL **REFLECTED CEILING PLAN**

A-A1-MB.02.01 SCALE 1:100

11 MB.02.01 COREE 1.100

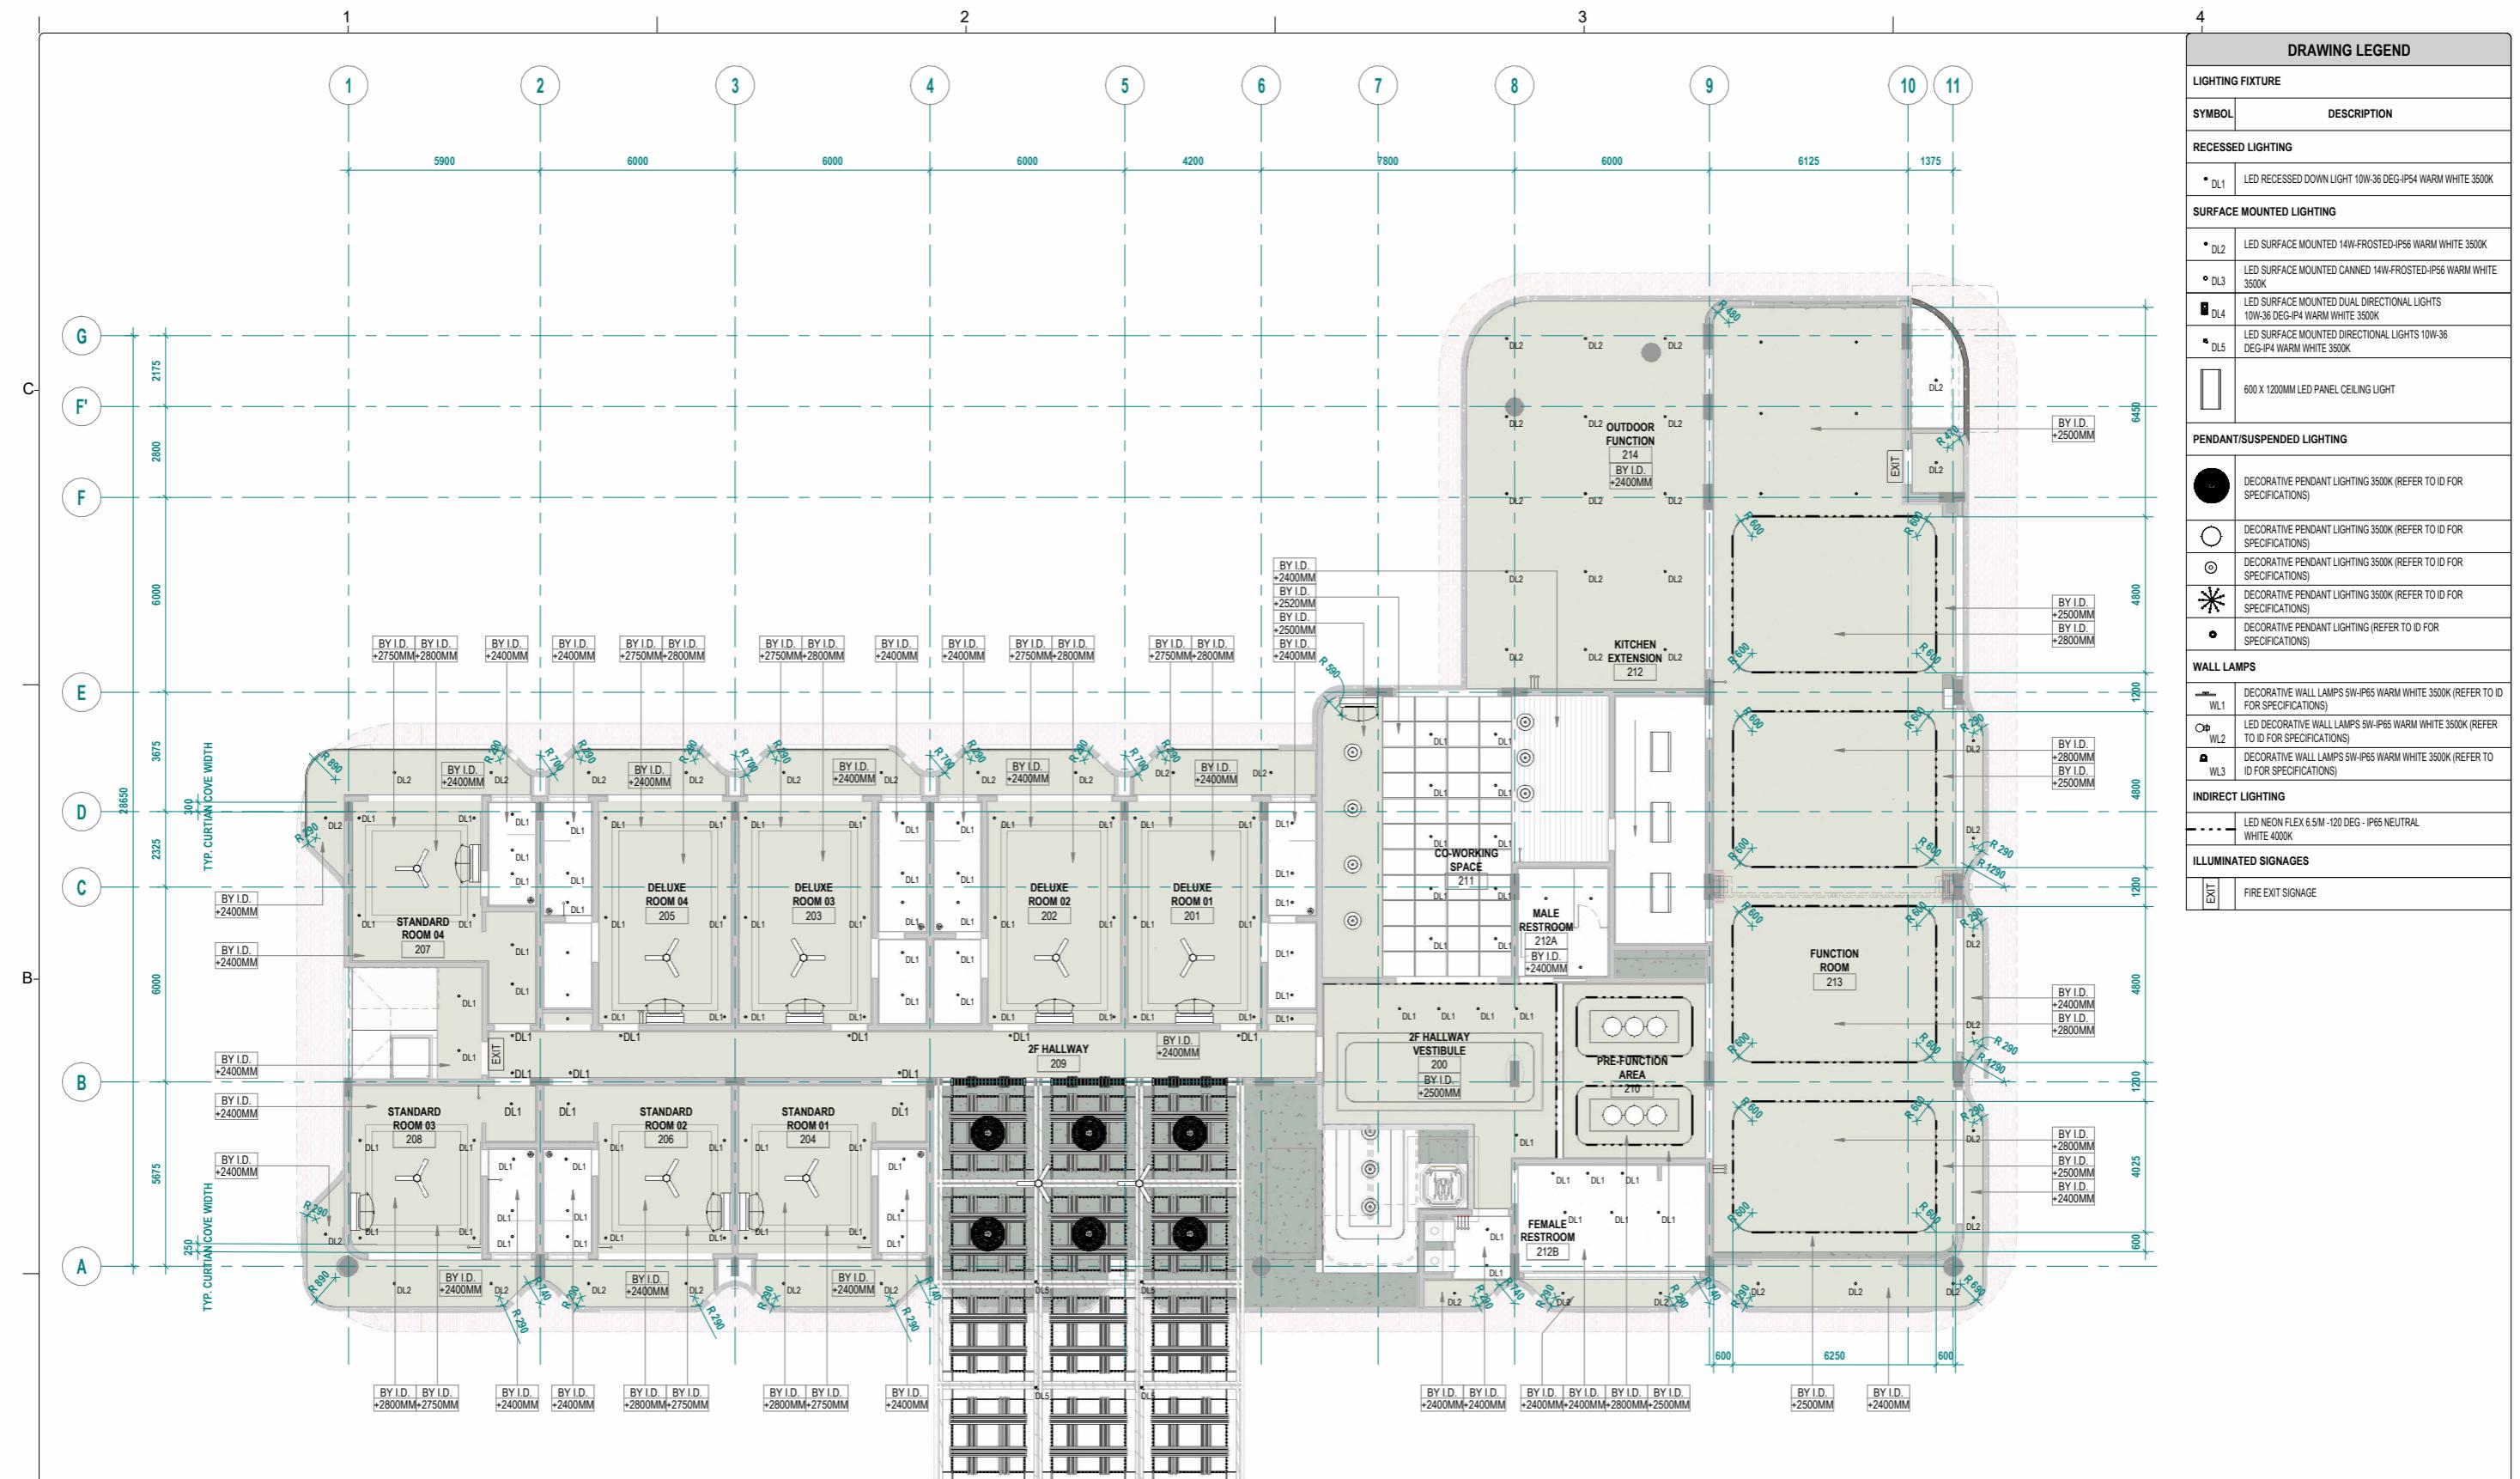

THE GREENHOUSE: PROPOSED 3-STOREY HOTEL BUILDING		CEILING PLANS	ISSUED BY: AR. DENISE DE CASTRO TIN NO.: ISSUED: REG. NO.: PTR. NO.: IAPOA NO.: REPUBLIC ACT 8988	DEQA DESIGN COLLABORATIVE	FASTCON STRUCTURAL/CIVIL WORKS	FASTCON MECHANICAL AND FIRE PROTECTION	FASTCON ELECTRICAL	FASTCON PLUMBING AND SANITARY	FASTCON ELCTRONICS	FASTCON LANDSCAPE	DRAWING REVISIONS
DESIGNED BY: DDC DATE ISSUED: 17-MAR-00 DATE PRINTED: 21/11/2024 11:04:44 am	CEILING PLANS MR. FREDERICK T. SIY TOURISM RD. Brgy. Catanagan, Gen. Luna, Surigao Del Norte	SHEET NO: A1-MB.02.02									NO. DATE BY DESCRIPTION
KEY PLAN											

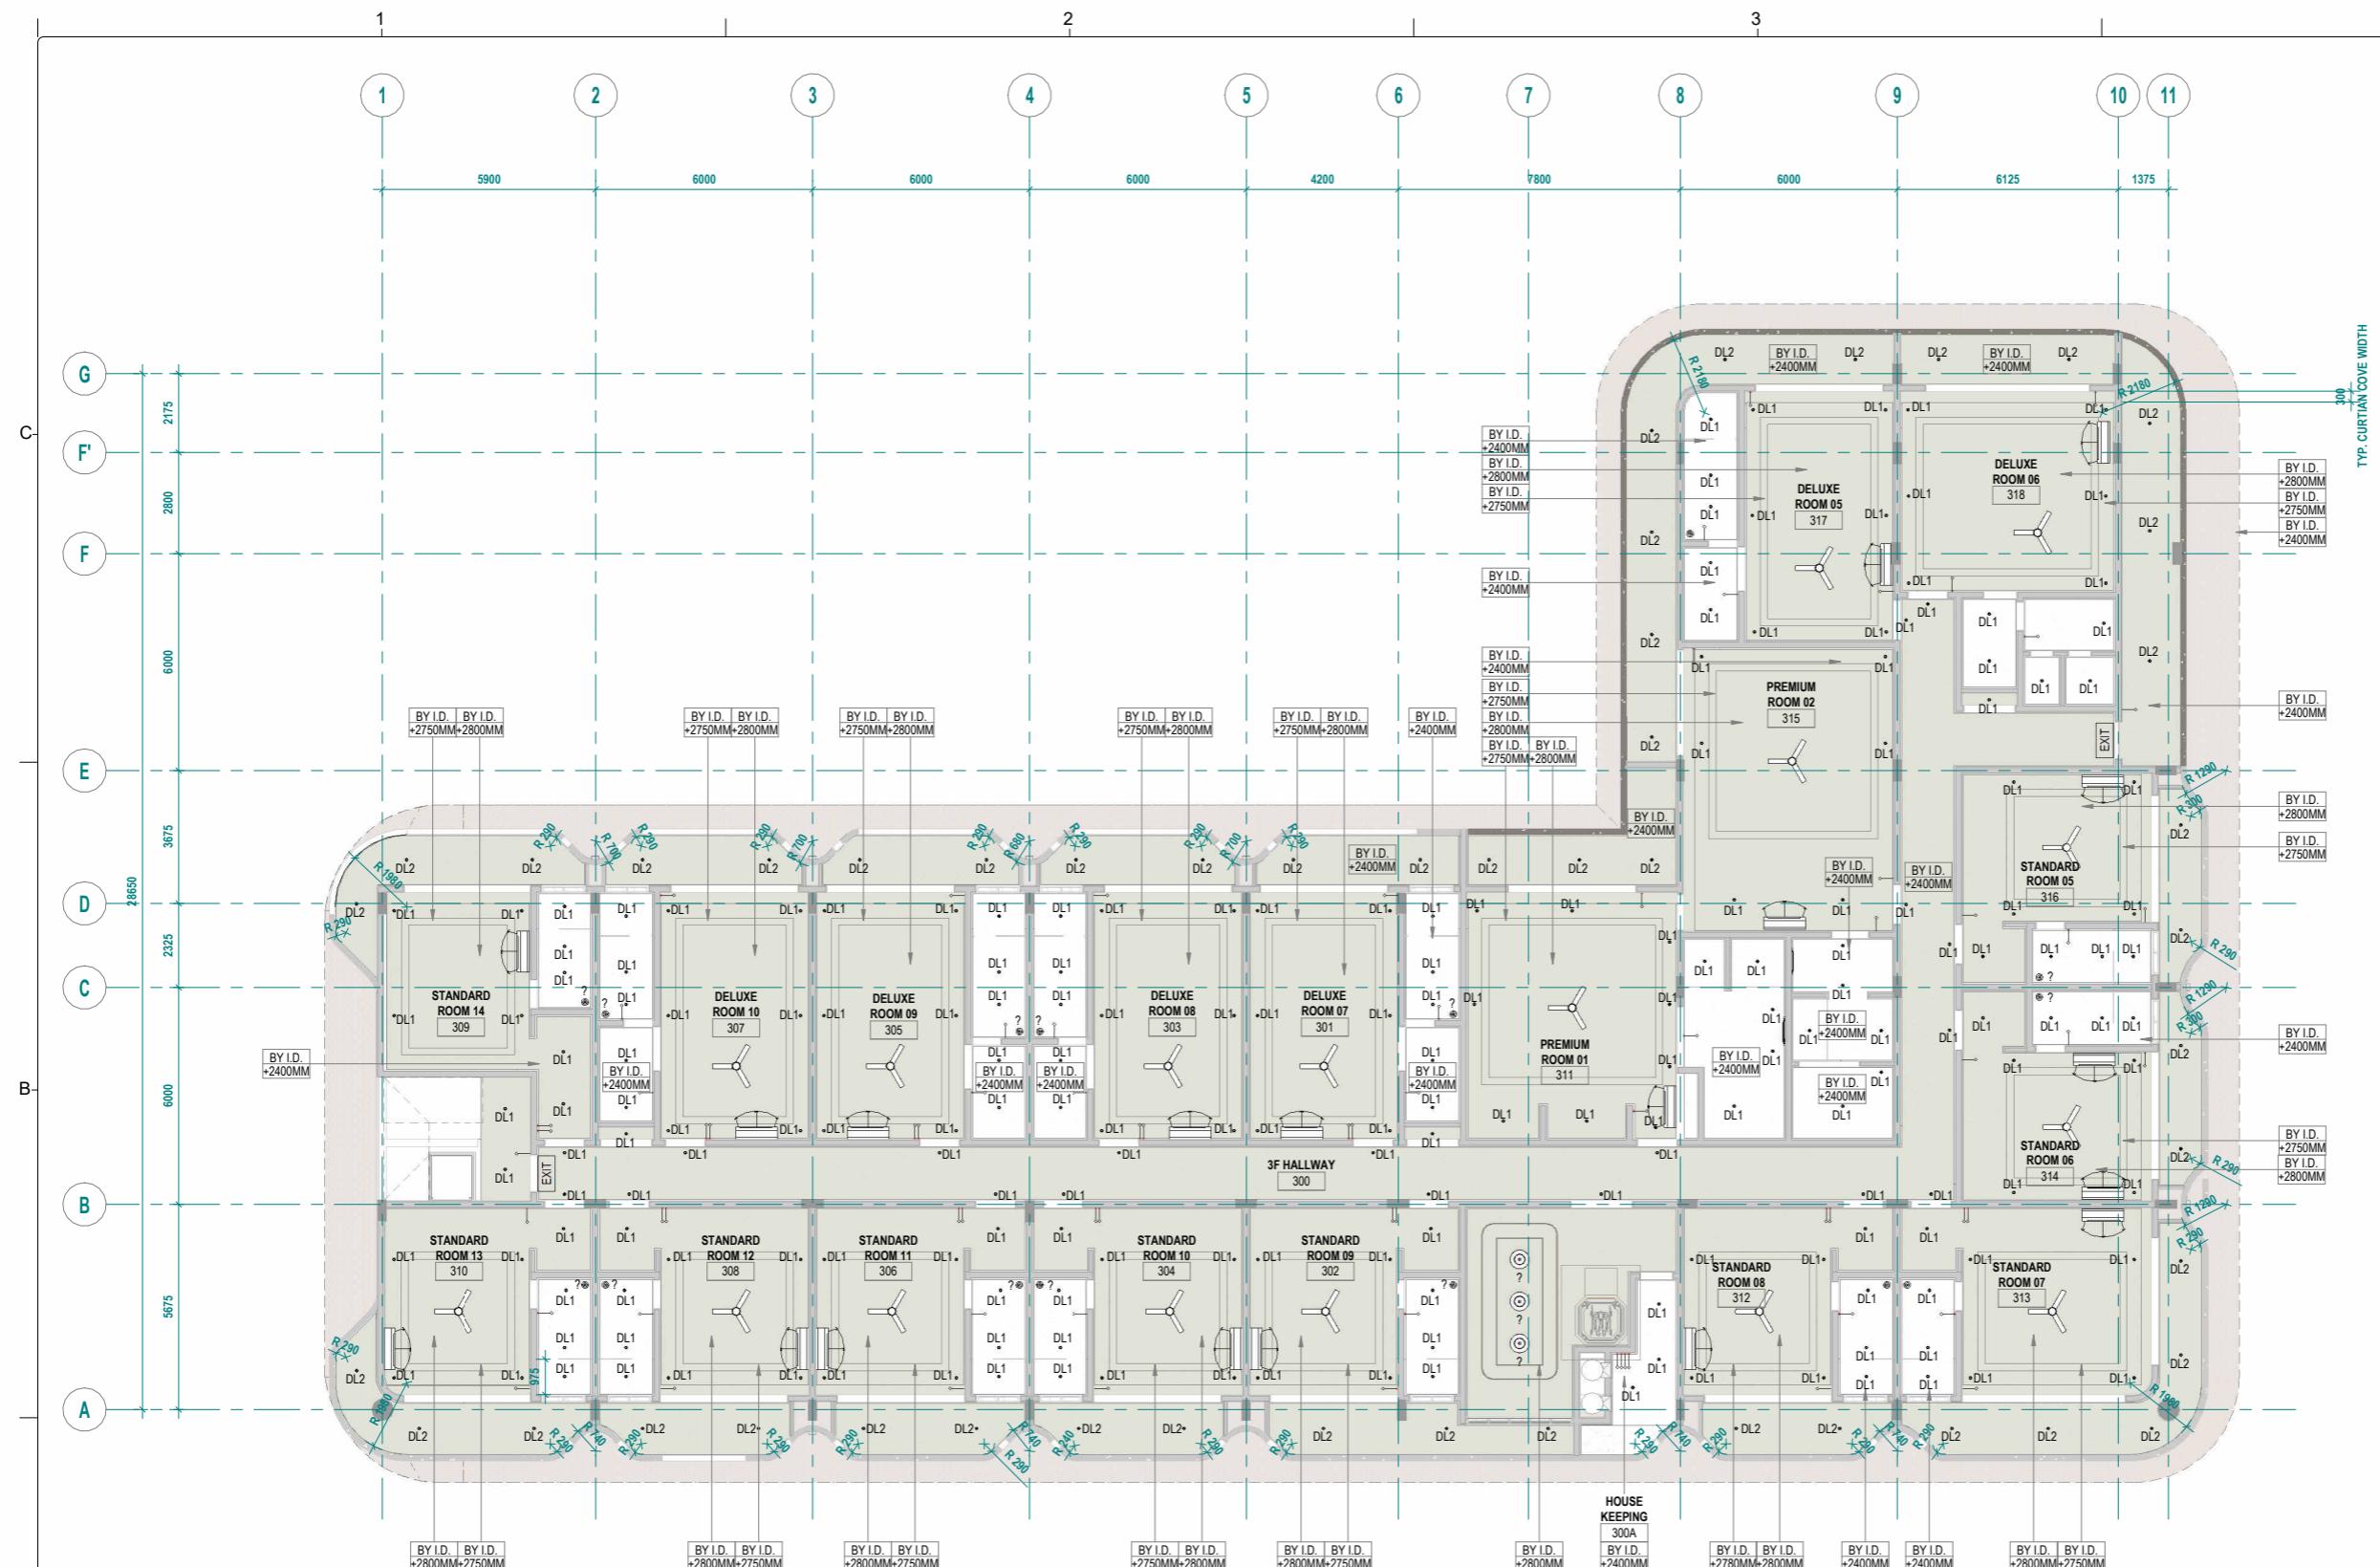

1 THIRD LEVEL
REFLECTED CEILING PLAN

A-A1-MB.02.03 SCALE 1:100

AT MD.02.00 GOAL 1.100

THE GREENHOUSE: PROPOSED 3-STORY HOTEL BUILDING	CEILING PLANS		ISSUED BY:  AR. DENISE DE CASTRO <hr/> TIN NO.: _____ ISSUED: ____/ <hr/> REG. NO.: _____ PTB. NO.: _____ IAPMO NO.: _____/_____ <hr/> DRAWINGS AND SPECIFICATIONS DULY SIGNED, STAMPED OR SEALED AS INSTRUMENTS OF SERVICE, ARE THE INTELLECTUAL PROPERTY AND DOCUMENTS OF THE ARCHITECT. WHETHER THE OBJECT FOR WHICH THEY ARE MADE IS EXECUTED OR NOT, IT SHALL BE UNLAWFUL FOR ANY PERSON WHO HAS RECEIVED THEM TO MAKE COPIES OF THEM OR TO COMMUNICATE THESE DOCUMENTS FOR USE IN THE REPETITION OF OTHER PROJECTS OR BUILDINGS. WHETHER EXECUTED PARTLY OR IN WHOLE.
	MR. FREDERICK T. SIY		
	TOURISM RD, BRGY. CATANGANAN, GEN. LUNA, SURIGAO DEL NORTE		
DESIGN DEVELOPMENT NOT FOR CONSTRUCTION	DESIGNED BY: DDC	SHEET NO: A1-MB.02.03	STRUCTURAL/CIVIL WORKS FASTCON MECHANICAL AND FIRE PROTECTION <hr/> ELECTRICAL FASTCON PLUMBING AND SANITARY <hr/> FASTCON ELectronics <hr/> LANDSCAPE
	DATE ISSUED: 17-MM-00	DATE PRINTED: 21/11/2024 11:05:00 am	SCALE: 1:100